

Appendix B

Lighting Plan

LIGHTING LEGEND

SYMBOL	QTY.	DESCRIPTION
	-	NEW TRANSFORMER - FX-FX-600W TRANSFORMER COLOR TO MATCH
	-	EXISTING J-BOX
	-	120V 6FI, WATERPROOF OUTLET
	-	LANDSCAPE LIGHT SWITCHES
(A)	-	FARO - LOTUS 350 DARK GREY 10W BEACON LAMP
(B)	-	IN-LITE - DISC 12V
(C)	-	B-K LIGHTING - MC-512-BLP, MC-MCKINLEY 6.5H SATIN BLACK W. TREE STRAP
(D)	-	WAK LIGHTING - HL-LED100-30-66-6H FILASTER WALL LIGHTS 3.4W @ 24'-30" HT. TO WASH GROUND @ BASE DRIVE, HALLS, STEPS
(E)	-	FX-LUMINAIRE - FB-3 LED-FB, 4W FLAT BLACK -GROUND MOUNTED
(F)	-	UNDER STRIP RAILINGS STRIP LIGHTS TO ILLUMINATE STEPS (T.B.D. BY ARCH)
	-	SWITCH CONDUIT
	-	ALL WORK UNDER PAVING TO SLEEVED.



(A) PATH LIGHTS
FARO - LOTUS 350 BEACON LAMP




(B) BOLLARD LIGHTS
IN-LITE - DISC 12V




(C) DOWN LIGHTING
B-K LIGHTING - MC-MCKINLEY W. TREE STRAP



(D) IN WALL LIGHTING
WAK LIGHTING - HL-LED100

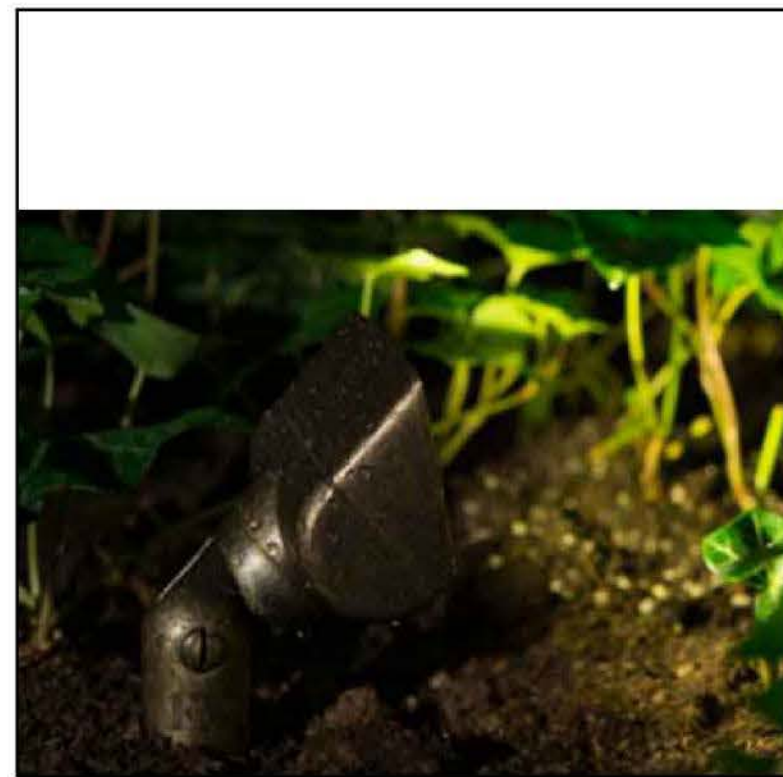


(E) SIGN LIGHTING @ ENTRY AND DIRECTIONAL SIGNAGE
FX-LUMINAIRE - FB LED LIGHT

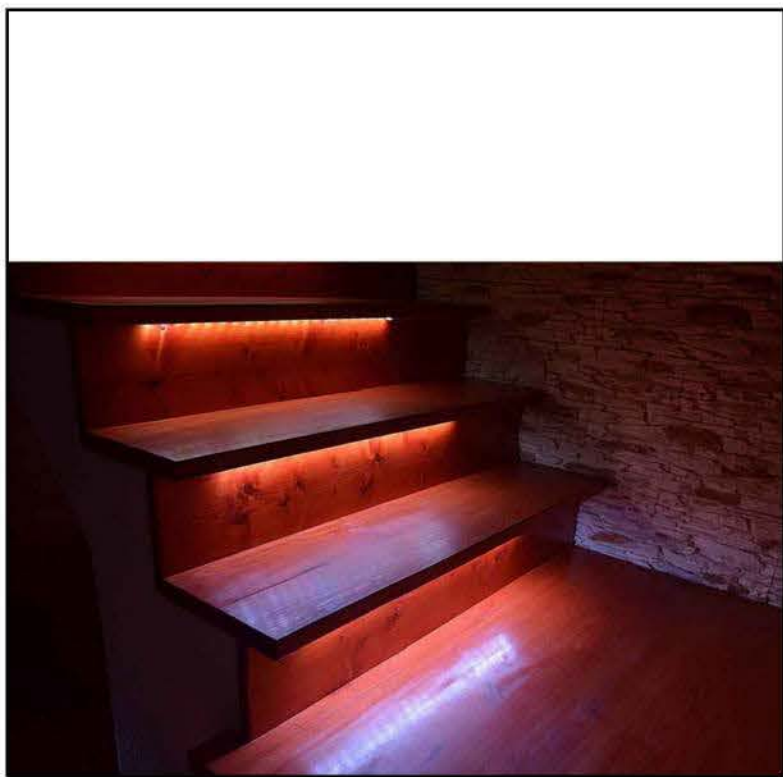

(F) UNDER STEP & HAND RAILS STRIP LIGHTS TO ILLUMINATE STEPS (T.B.D. BY ARCH)

LIGHTING INSTALLATION NOTES

- 1) PHOTO CELL SYSTEMS TIMING T.B.D.
- 2) ALL SYSTEMS SHALL HAVE SWITCH OVERRIDE CAPABILITY
- 3) LOCATE ALL LOW VOLTAGE WIRES IN CONDUIT. BURY A MIN. OF 3".
- 4) WELL OR ACCENT LIGHTS TO BE DETERMINED IN FIELD BY LANDSCAPE ARCHITECT BASED ON QUALITY OF LIGHT IN TREE CANOPY.
- 5) ALL CABLE IS TO BE APPROPRIATELY SIZED PER LENGTH OF RUN & LOAD BY ELECTRICIAN.

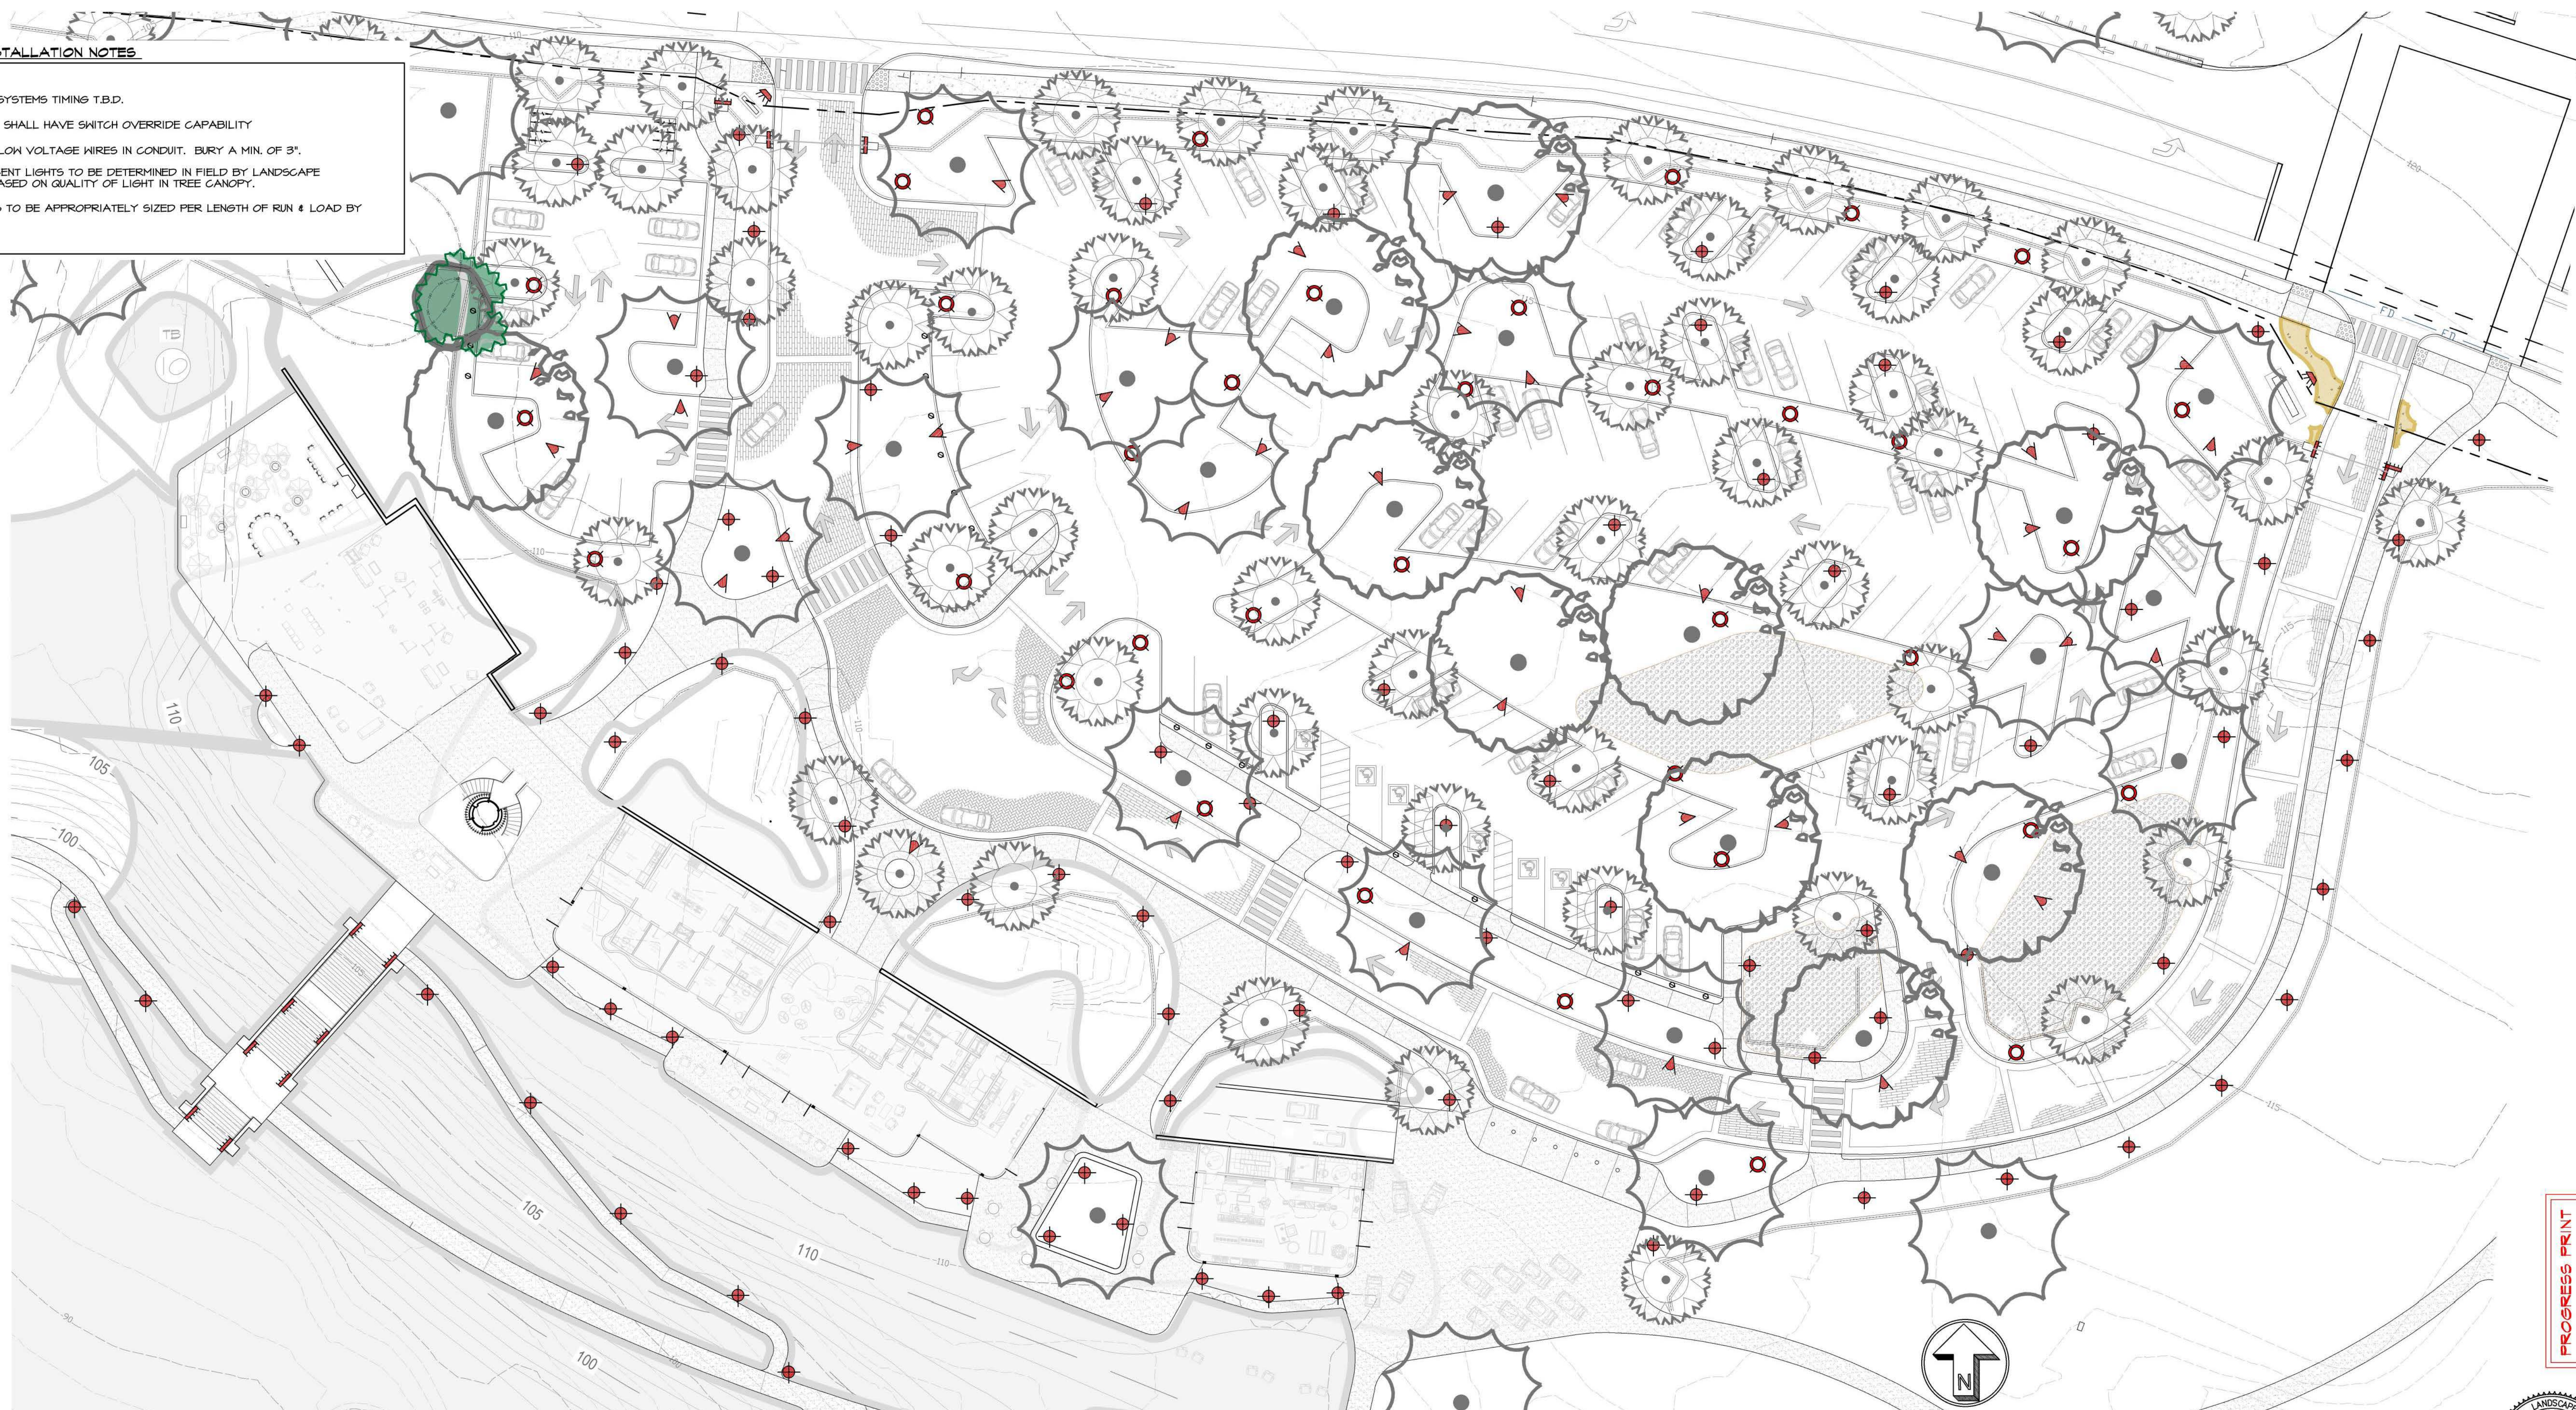

SANDPIPER GOLF CLUB -CLUBHOUSE PRELIMINARY LIGHTING PLAN

NORTH

SCALE: 1" = 20'-0"

The landscape architect and his consultants do not warrant or guarantee the accuracy and completeness of the work product herein beyond a reasonable diligence. If any mistakes, omissions, or discrepancies are found to exist within the work product, the landscape architect shall be promptly notified so that he may have the opportunity to take whatever steps necessary to resolve them. Failure to promptly notify the landscape architect of such conditions shall relieve the landscape architect from any responsibility for the consequences of such discrepancies. Actions without the knowledge and consent of the landscape architect or in contradiction to the landscape architect work product or recommendations shall become the responsibility not of the landscape architect but of the parties responsible taken. Such action, this plan and design are the exclusive property of Earthform Design and cannot be used or reproduced without the landscape architect's written consent.

REVISIONS BY

EARTHFORM
DESIGN
LANDSCAPE ARCHITECTURE - LAND PLANNING - URBAN DESIGN
TEL: (805) 983-5006 FAX: (805) 983-8335

SANDPIPER GOLF CLUB -CLUBHOUSE
PRELIMINARY LIGHTING PLAN

SANDPIPER GOLF CLUB
7925 HOLLISTER AVE.
GOLETA, CA. 93117

11/06/23
Scale: 1" = 20'-0"
Drawn: N.T.
Job: SANDPIPER
Print Date:
Sheet: L-2
Of: 2 Sheets

PROGRESS PRINT
NOT FOR CONSTRUCTION




LIGHTING LEGEND

SYMBOL	QTY.	DESCRIPTION
	-	NEW TRANSFORMER -FX-FX-600W TRANSFORMER COLOR TO MATCH
	-	EXISTING J-BOX
	-	120V 6FI, WATERPROOF OUTLET
	-	LANDSCAPE LIGHT SWITCHES
(A)	-	FARO - LOTUS 350 DARK GREY 10W BEACON LAMP
(B)	-	IN-LITE - DISC 12V
(C)	-	B-K LIGHTING - MC-512-BLP, MC-MCKINLEY 6.5W SATIN BLACK W. TREE STRAP
(D)	-	WAK LIGHTING - KL-LED100-30-66-6H FILASTER WALL LIGHTS 3.4W @ 24"-30" HT. TO WASH GROUND @ BASE DRIVE, WALLS, STEPS
(E)	-	FX-LUMINAIRE - PB-3 LED-FB, 4W FLAT BLACK -GROUND MOUNTED
(F)	-	UNDER STRIP RAILINGS STRIP LIGHTS TO ILLUMINATE STEPS (T.B.D. by ARCH)
	-	SWITCH CONDUIT
	-	ALL WORK UNDER PAVING TO SLEEVED.



(A) PATH LIGHTS
FARO - LOTUS 350 BEACON LAMP

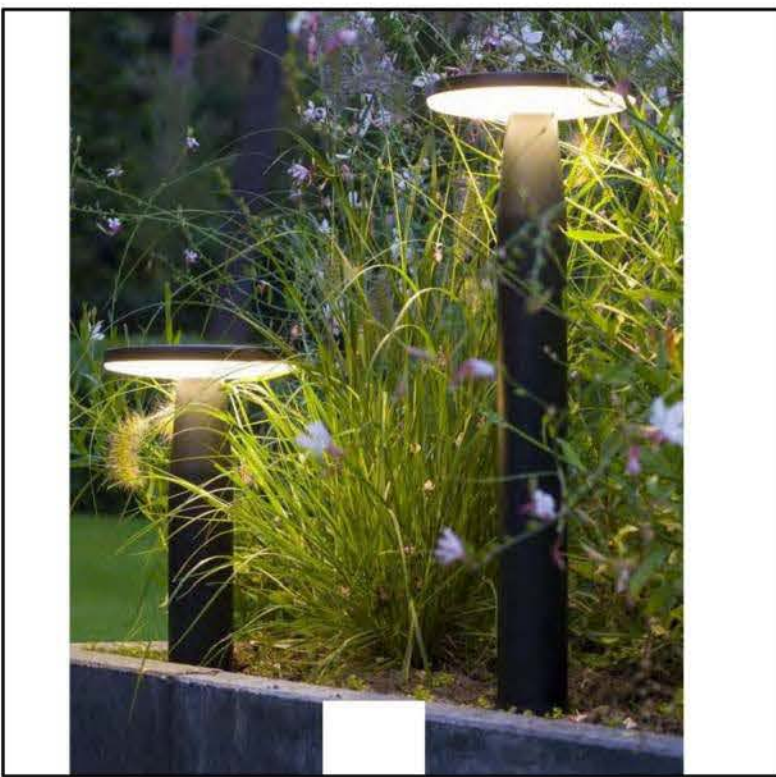


(B) BOLLARD LIGHTS
IN-LITE - DISC 12V




(C) DOWN LIGHTING
B-K LIGHTING - MC-MCKINLEY W. TREE STRAP



(D) IN WALL LIGHTING
WAK LIGHTING - KL-LED100

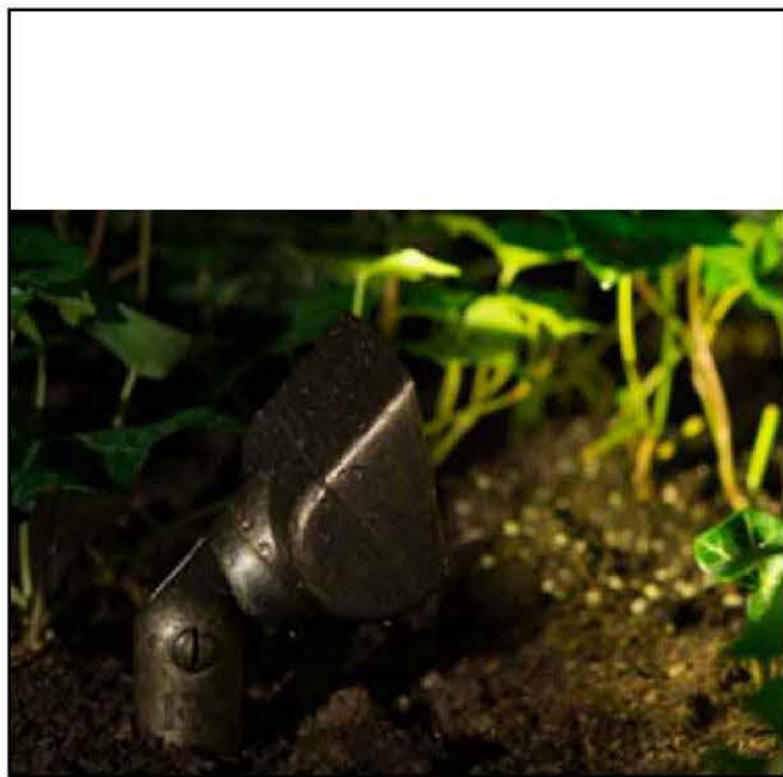


(E) SIGN LIGHTING @ ENTRY AND DIRECTIONAL SIGNAGE
FX-LUMINAIRE - PB LED LIGHT

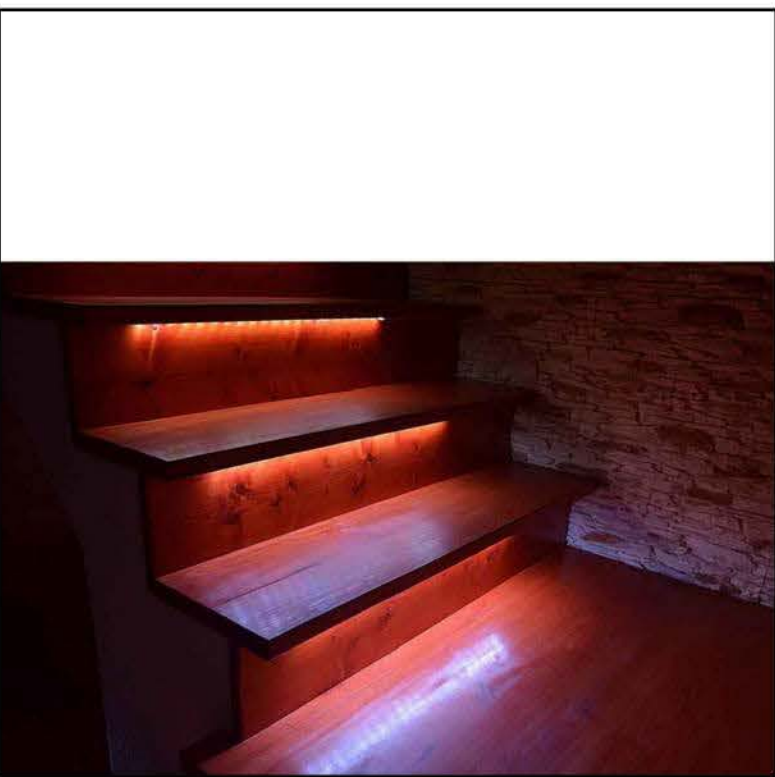


(F) UNDER STEP 4 HAND RAILS STRIP LIGHTS TO ILLUMINATE STEPS (T.B.D. by ARCH)

LIGHTING INSTALLATION NOTES

- 1) PHOTO CELL SYSTEMS TIMING T.B.D.
- 2) ALL SYSTEMS SHALL HAVE SWITCH OVERRIDE CAPABILITY
- 3) LOCATE ALL LOW VOLTAGE WIRES IN CONDUIT. BURY A MIN. OF 3".
- 4) WELL OR ACCENT LIGHTS TO BE DETERMINED IN FIELD BY LANDSCAPE ARCHITECT BASED ON QUALITY OF LIGHT IN TREE CANOPY.
- 5) ALL CABLE IS TO BE APPROPRIATELY SIZED PER LENGTH OF RUN & LOAD BY ELECTRICIAN.

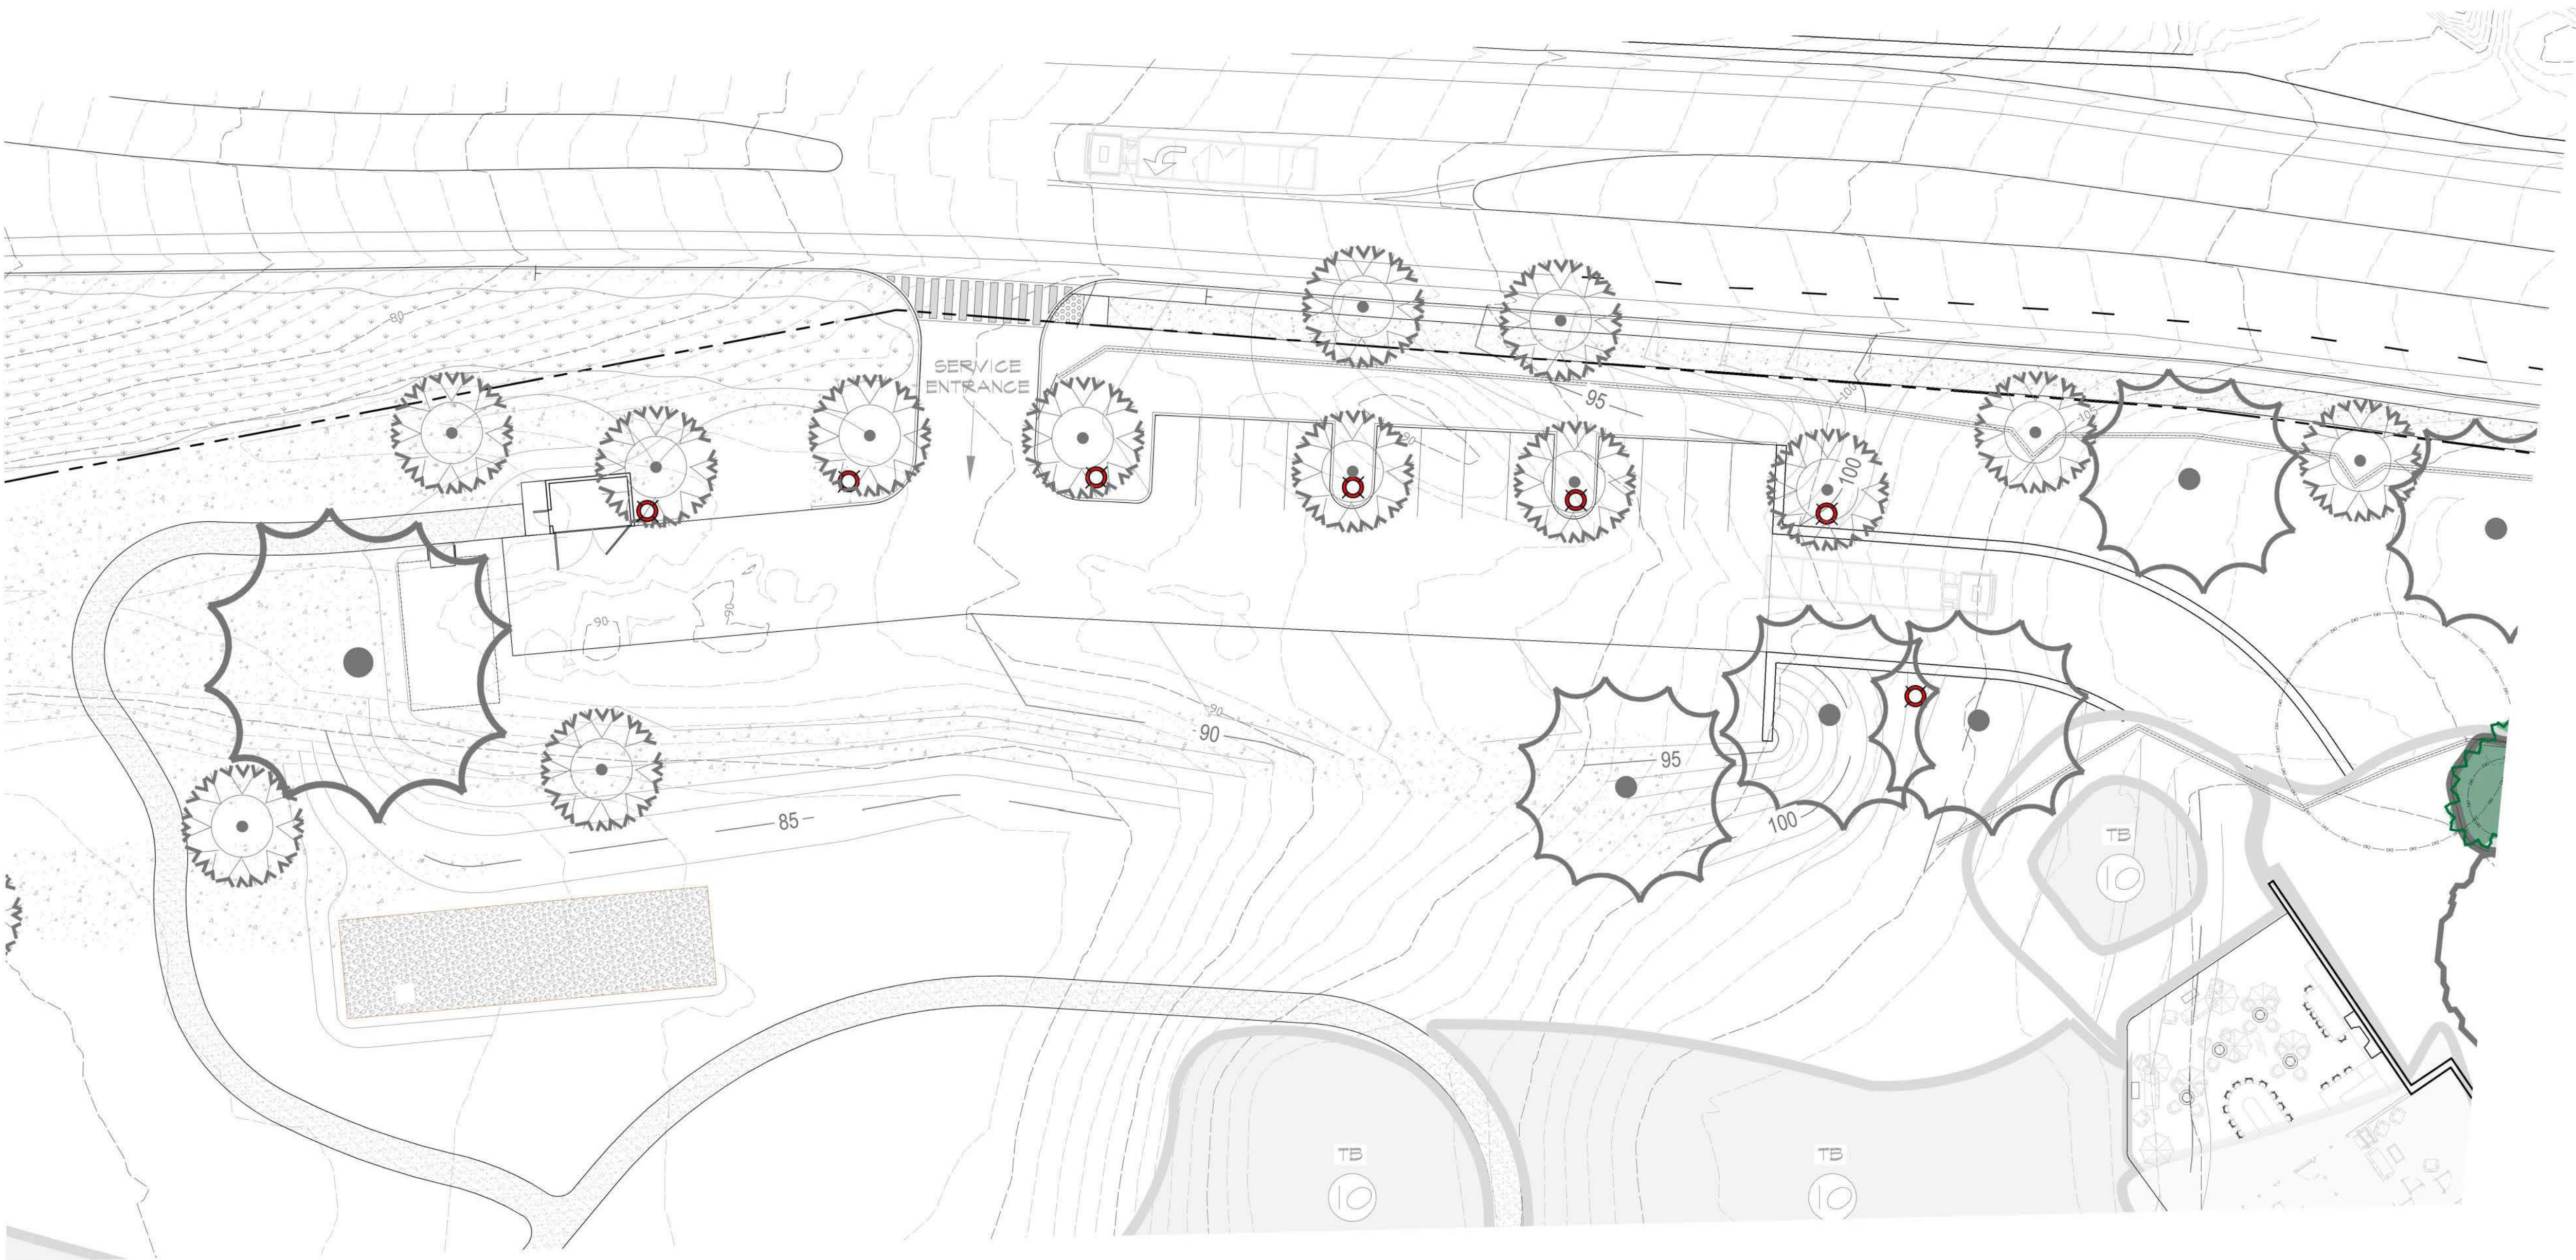

SANDPIPER GOLF CLUB -WEST PARKING LOT PRELIMINARY LIGHTING PLAN

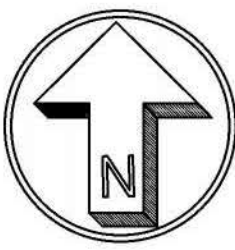

NORTH

SCALE: 1" = 20'-0"

PROGRESS PRINT
NOT FOR CONSTRUCTION



SANDPIPER GOLF CLUB
7925 HOLLISTER AVE.
GOLETA, CA. 93117

SANDPIPER GOLF CLUB -WEST PARKING LOT
PRELIMINARY LIGHTING PLAN

EARTHFORM
DESIGN
LANDSCAPE ARCHITECTURE - LAND PLANNING - URBAN DESIGN
TEL: (805) 983-5006 FAX: (805) 983-5335


REVISIONS	BY

Date	11/06/23
Scale	1"=20'-0"
Drawn	N.T.
Job	SANDPIPER
Print Date	
Sheet	1-2.1
Of	2

SYMBOL	QTY.	DESCRIPTION
--------	------	-------------

	-	NEW TRANSFORMER -FX-FX-600W TRANSFORMER COLOR TO MATCH
	-	EXISTING J-BOX
	-	120V GFI, WATERPROOF OUTLET
	-	LANDSCAPE LIGHT SWITCHES
(A) 	-	FARO - LOTUS 350 DARK GREY 18w BEACON LAMP
(B) 	-	IN-LITE - DISC 12V
(C) 	-	B-K LIGHTING - MC-512-BLP; MC-MCKINLEY 6.5w SATIN BLACK w. TREE STRAP
(D) 	-	WAK LIGHTING - WL-LED100-30-58-6H PILASTER WALL LIGHTS 3.9w @ 24"-30" HT. TO WASH GROUND @ BASE DRIVE, WALLS, STEPS
(E) 	-	FX-LUMINAIRE - FB-3 LED-FB; 4H FLAT BLACK -GROUND MOUNTED
(F) 	-	UNDER STRIP RAILING STRIP LIGHTS TO ILLUMINATE STEPS (T.B.D. by ARCH)
		SKITCH CONDUIT
		ALL WORK UNDER PAVING TO SLEEVED.

- 1) PHOTO CELL SYSTEMS TIMING T.B.D.
- 2) ALL SYSTEMS SHALL HAVE SWITCH OVERRIDE CAPABILITY
- 3) LOCATE ALL LOW VOLTAGE WIRES IN CONDUIT. BURY A MIN. OF 3".
- 4) WELL OR ACCENT LIGHTS TO BE DETERMINED IN FIELD BY LANDSCAPE ARCHITECT BASED ON QUALITY OF LIGHT IN TREE CANOPY.
- 5) ALL CABLE IS TO BE APPROPRIATELY SIZED PER LENGTH OF RUN & LOAD BY ELECTRICIAN.

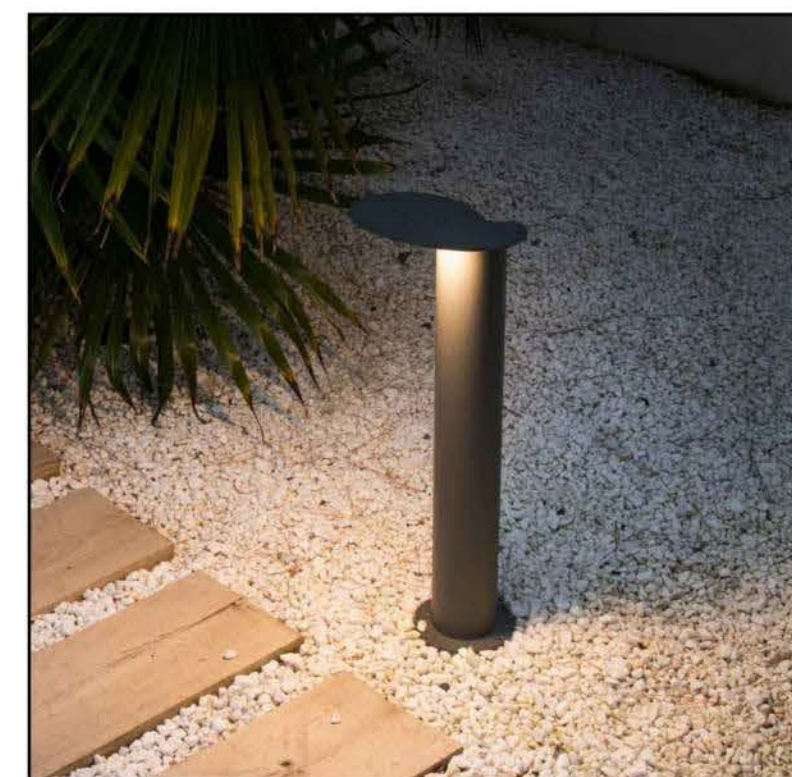

(A) 
PATH LIGHTS
FARO - LOTUS 650 BEACON LAMP



(B) 
BOLLARD LIGHTS
IN-LITE - DISC 12V




(c) 

DOWN LIGHTING

B-K LIGHTING - MC-MCKINLEY
w. TREE STRAP




(D) 
IN WALL LIGHTING
WAK LIGHTING - WL-LED100

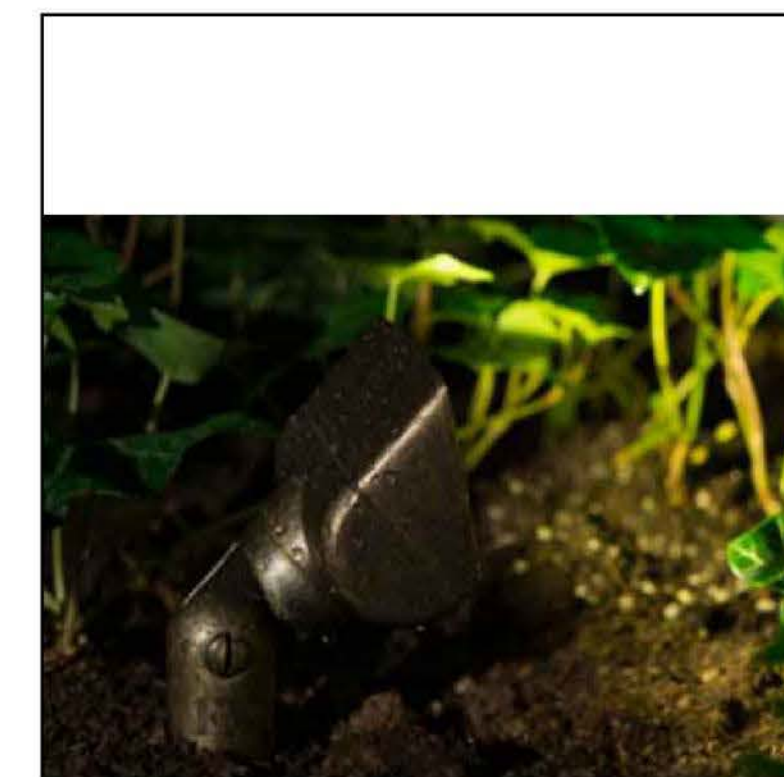

(E) 



SIGN LIGHTING @ ENTRY AND
DIRECTIONAL SIGNAGE

FX-LUMINAIRE - PB LED LIGHT

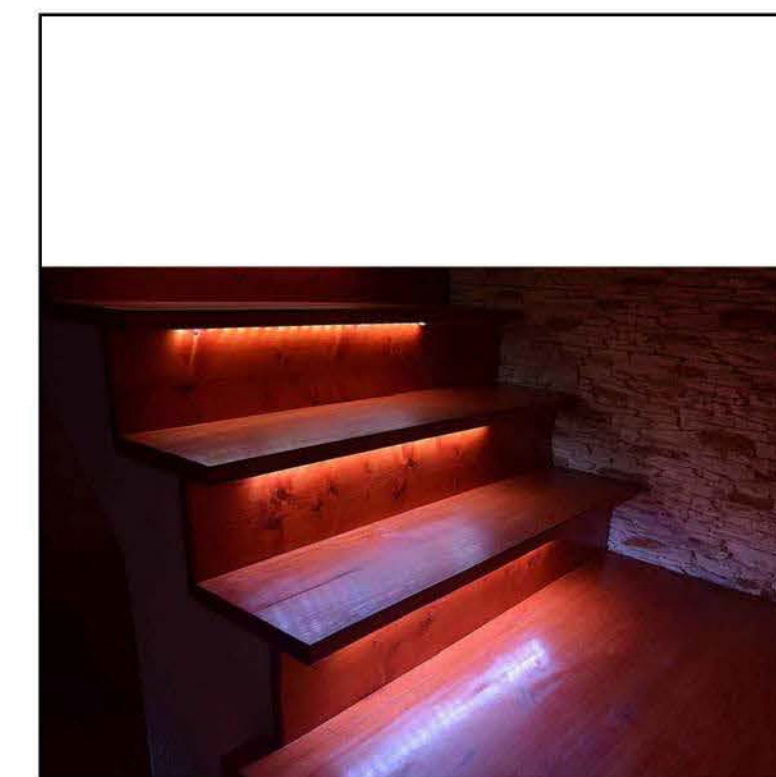

(F)

UNDER STEP 4 HAND RAILS STRIP LIGHTS
TO ILLUMINATE STEPS (T.B.D. by ARCH.)

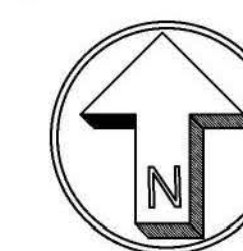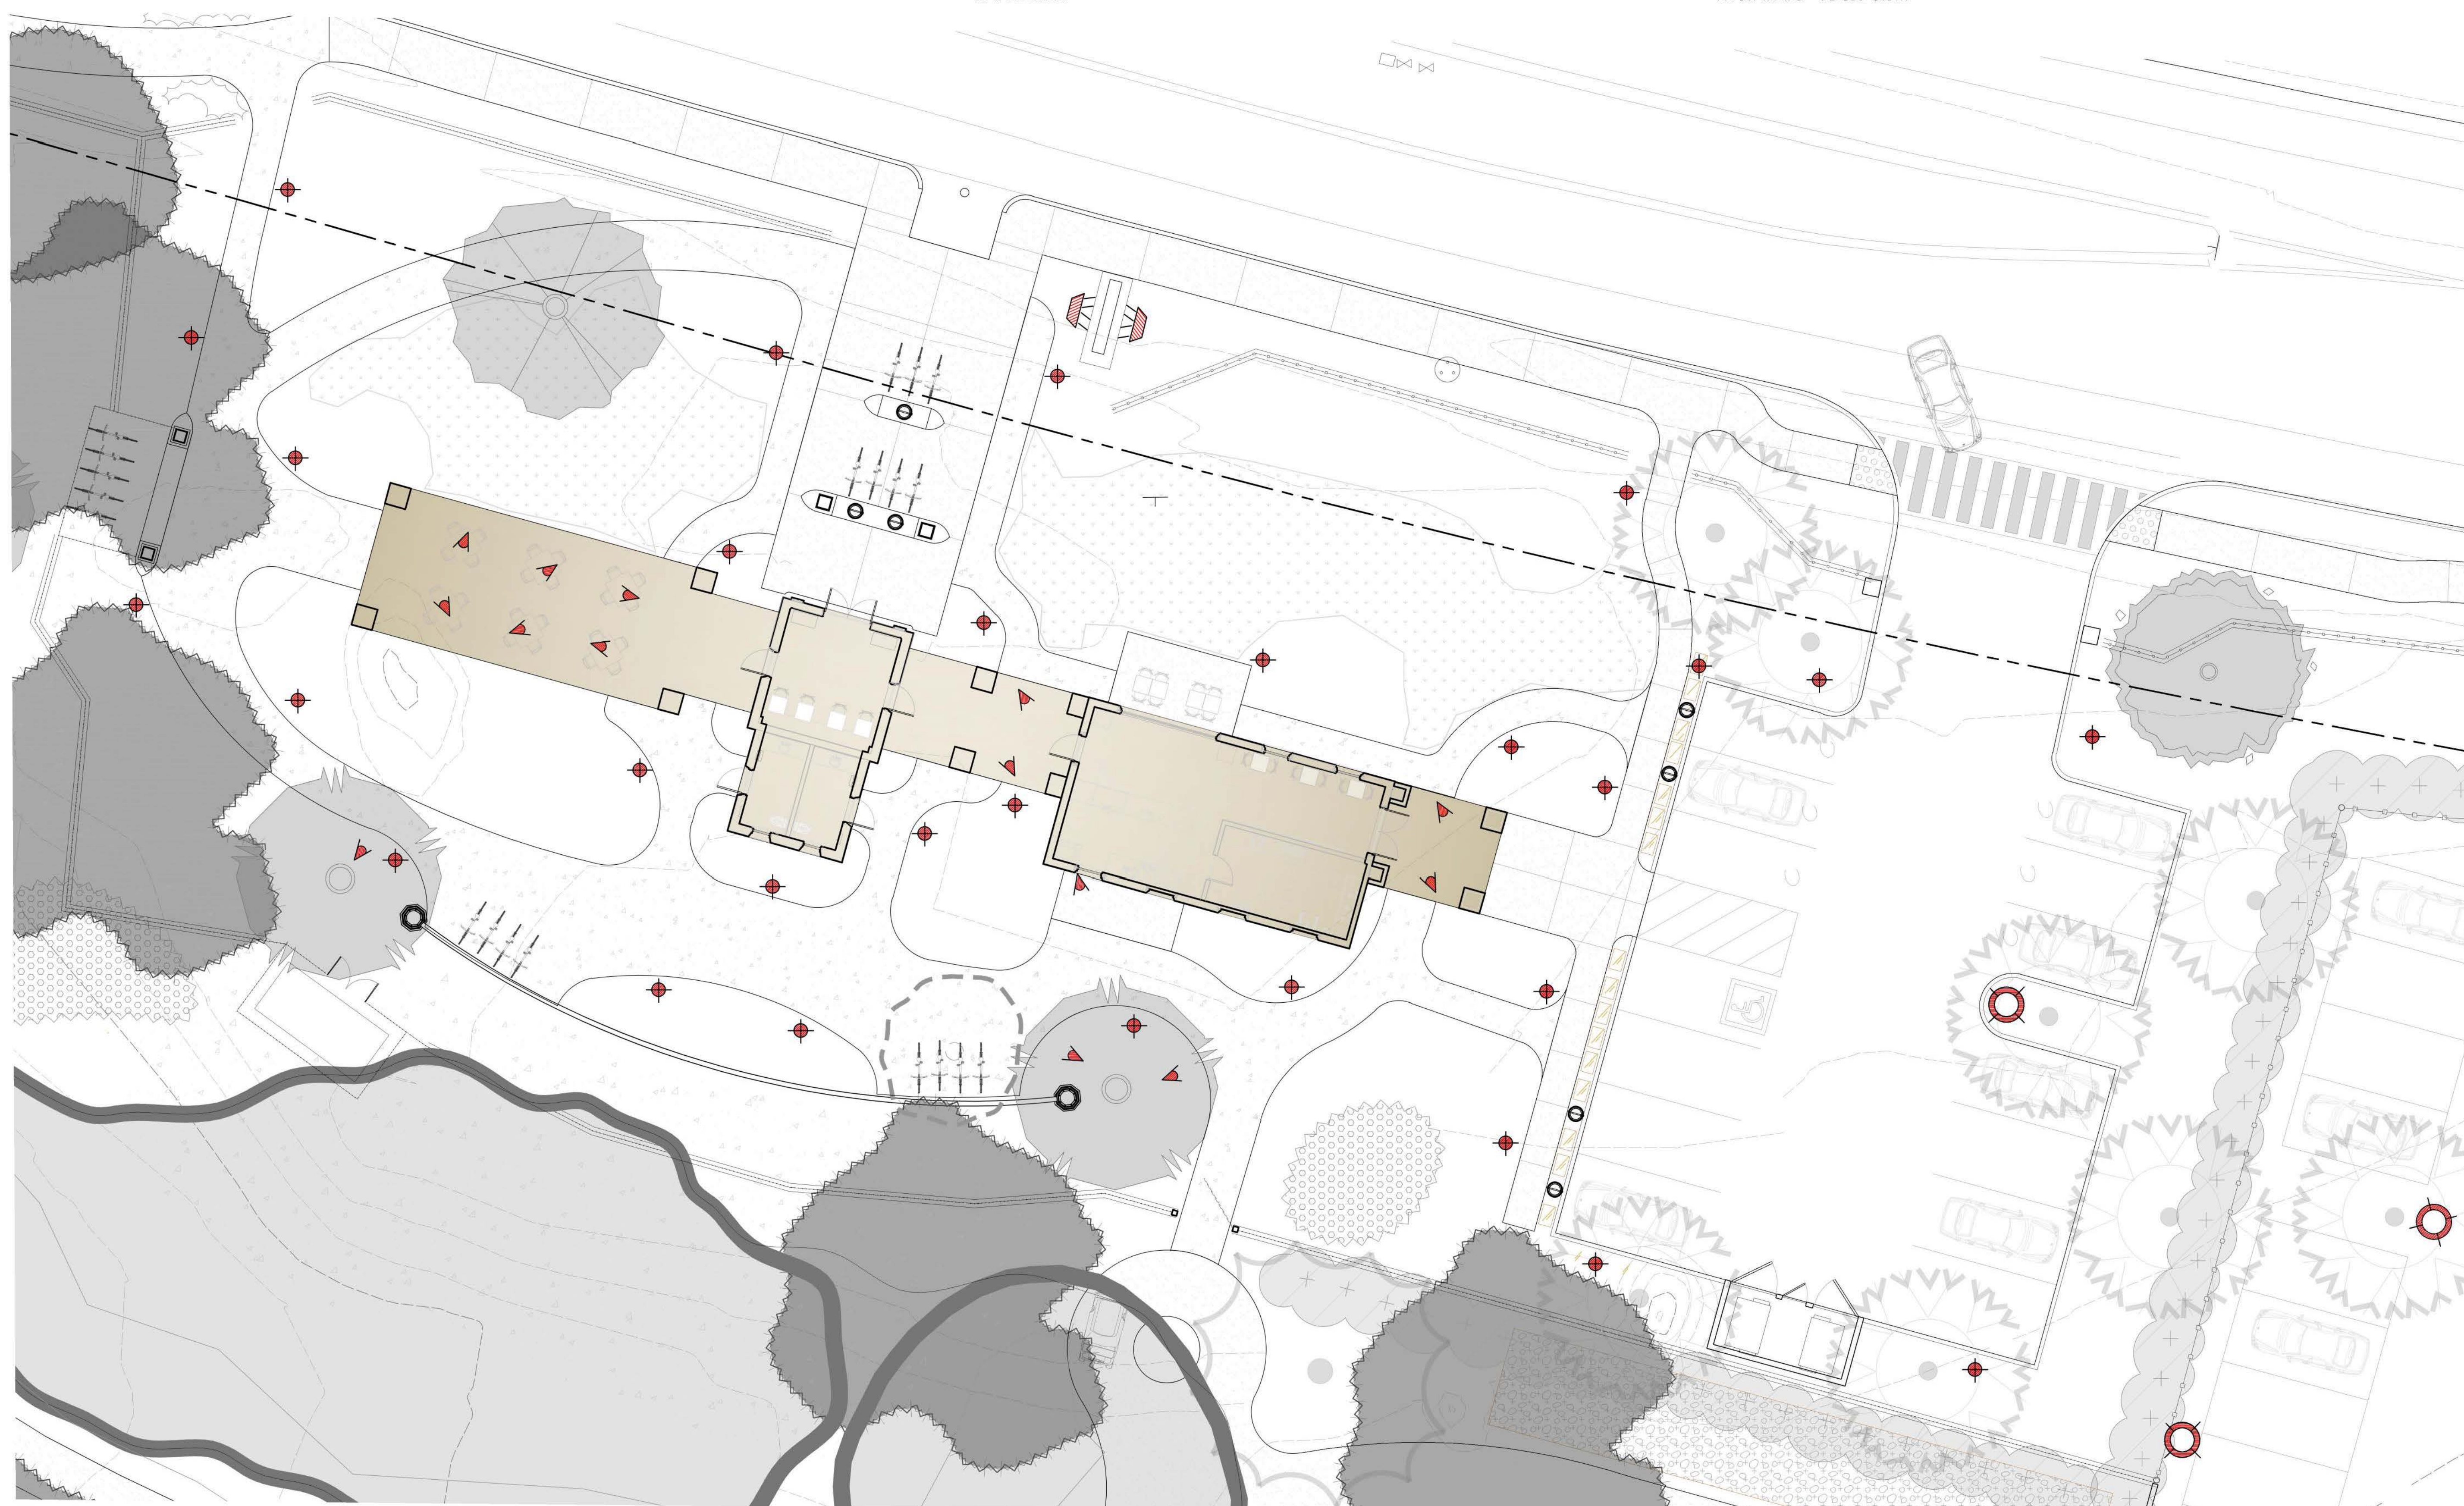

NORTH

SCALE: 1" = 10'-0"

SANDPIPER GOLF CLUB -BARNSDALL PRELIMINARY LIGHTING PLAN





PROGRESS PRINT
NOT FOR CONSTRUCTION



The landscape architect and his consultants do not warrant or guarantee the accuracy and completeness of the work product herein beyond a reasonable diligence. If any mistakes, omissions, or discrepancies are found to exist within the work product, the landscape architect shall be promptly notified so that he may have the opportunity to take whatever steps necessary to resolve them. Failure to promptly notify the landscape architect of such conditions shall absolve the landscape architect from any responsibility for the consequences of such discrepancies. Actions without the knowledge and consent of the landscape architect or in contradistinction to the landscape architects work product or recommendations shall become the responsibility not of the landscape architect but of the parties responsible taken such action. This plan and design are the exclusive property of Earthform Design and cannot be used or reproduced without the landscape architects written consent.

SYMBOL	QTY.	DESCRIPTION
	-	NEW TRANSFORMER -FX-FX-600W TRANSFORMER COLOR TO MATCH
	-	EXISTING J-BOX
	-	120V GFI, WATERPROOF OUTLET
	-	LANDSCAPE LIGHT SWITCHES
(A)	-	FARO - LOTUS 350 DARK GREY 12w BEACON LIGHT
(B)	-	IN-LITE - DISC 12V
(C)	-	B-K LIGHTING - MC-512-BLP, MC-MCKINLEY 6.5w SATIN BLACK w. TREE STRAP
(D)	-	WAK LIGHTING - WL-LED100-30-60-6H FLAFLAR WALL LIGHTS 3.9w @ 24"-30" HT. TO WASH GROUND @ BASE DRIVE, WALLS, STEPS
(E)	-	FX-LUMINAIRE - PB-3 LED-FB; 4w FLAT BLACK -GROUND MOUNTED
(F)	-	UNDER STRIP RAILING STRIP LIGHTS TO ILLUMINATE STEPS (T.B.D. by ARCH)
		SWITCH CONDUIT
== == ==		ALL WORK UNDER PAVING TO SLEEVED.

- 1) PHOTO CELL SYSTEMS TIMING T.B.D.
- 2) ALL SYSTEMS SHALL HAVE SWITCH OVERRIDE CAPABILITY
- 3) LOCATE ALL LOW VOLTAGE WIRES IN CONDUIT. BURY A MIN. OF 3".
- 4) WELL OR ACCENT LIGHTS TO BE DETERMINED IN FIELD BY LANDSCAPE ARCHITECT BASED ON QUALITY OF LIGHT IN TREE CANOPY.
- 5) ALL CABLE IS TO BE APPROPRIATELY SIZED PER LENGTH OF RUN & LOAD BY ELECTRICIAN.

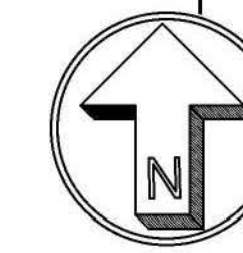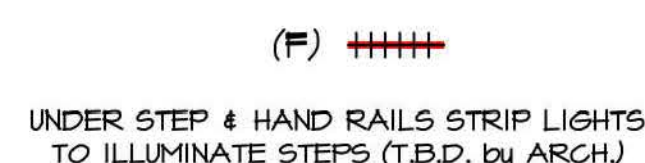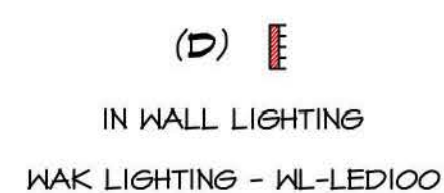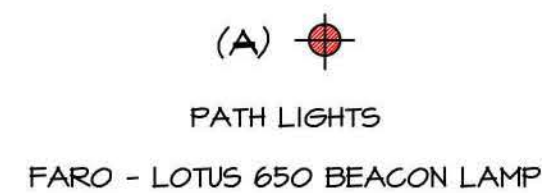

NORTH

SCALE: 1" = 20'-0"

SANDPIPER GOLF CLUB -MAINTENANCE YARD PRELIMINARY LIGHTING PLAN

PROGRESS PRINT
NOT FOR CONSTRUCTION



EARTHFORM
DESIGN
LANDSCAPE ARCHITECTURE • LAND PLANNING • URBAN DESIGN
1227 DE LA VINA ST. SANTA BARBARA, CALIFORNIA 93101
TEL: (805) 963-2006 • FAX: (805) 963-8335

SANDPIPER GOLF CLUB -MAINTENANCE YARD

PRELIMINARY LIGHTING PLAN

SANDPIPER GOLF CLUB
7925 HOLLISTER AVE.
GOLETA, CA. 93117

Date 11/06/23
Scale 1"=20'-0"
Drawn N.T.
Job SANDPIPER
Print Date
Sheet
L-23

Date	11/06/23
Scale	1"=20'-0"
Drawn	N.T.
Job	SANDPIPER
Print Date	
Sheet	L-2.3