
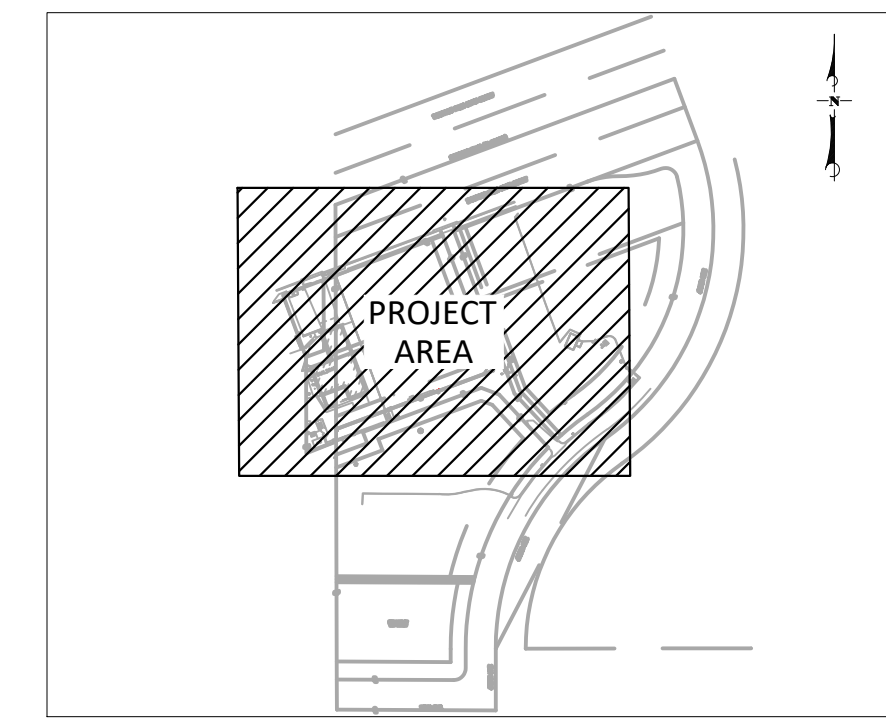


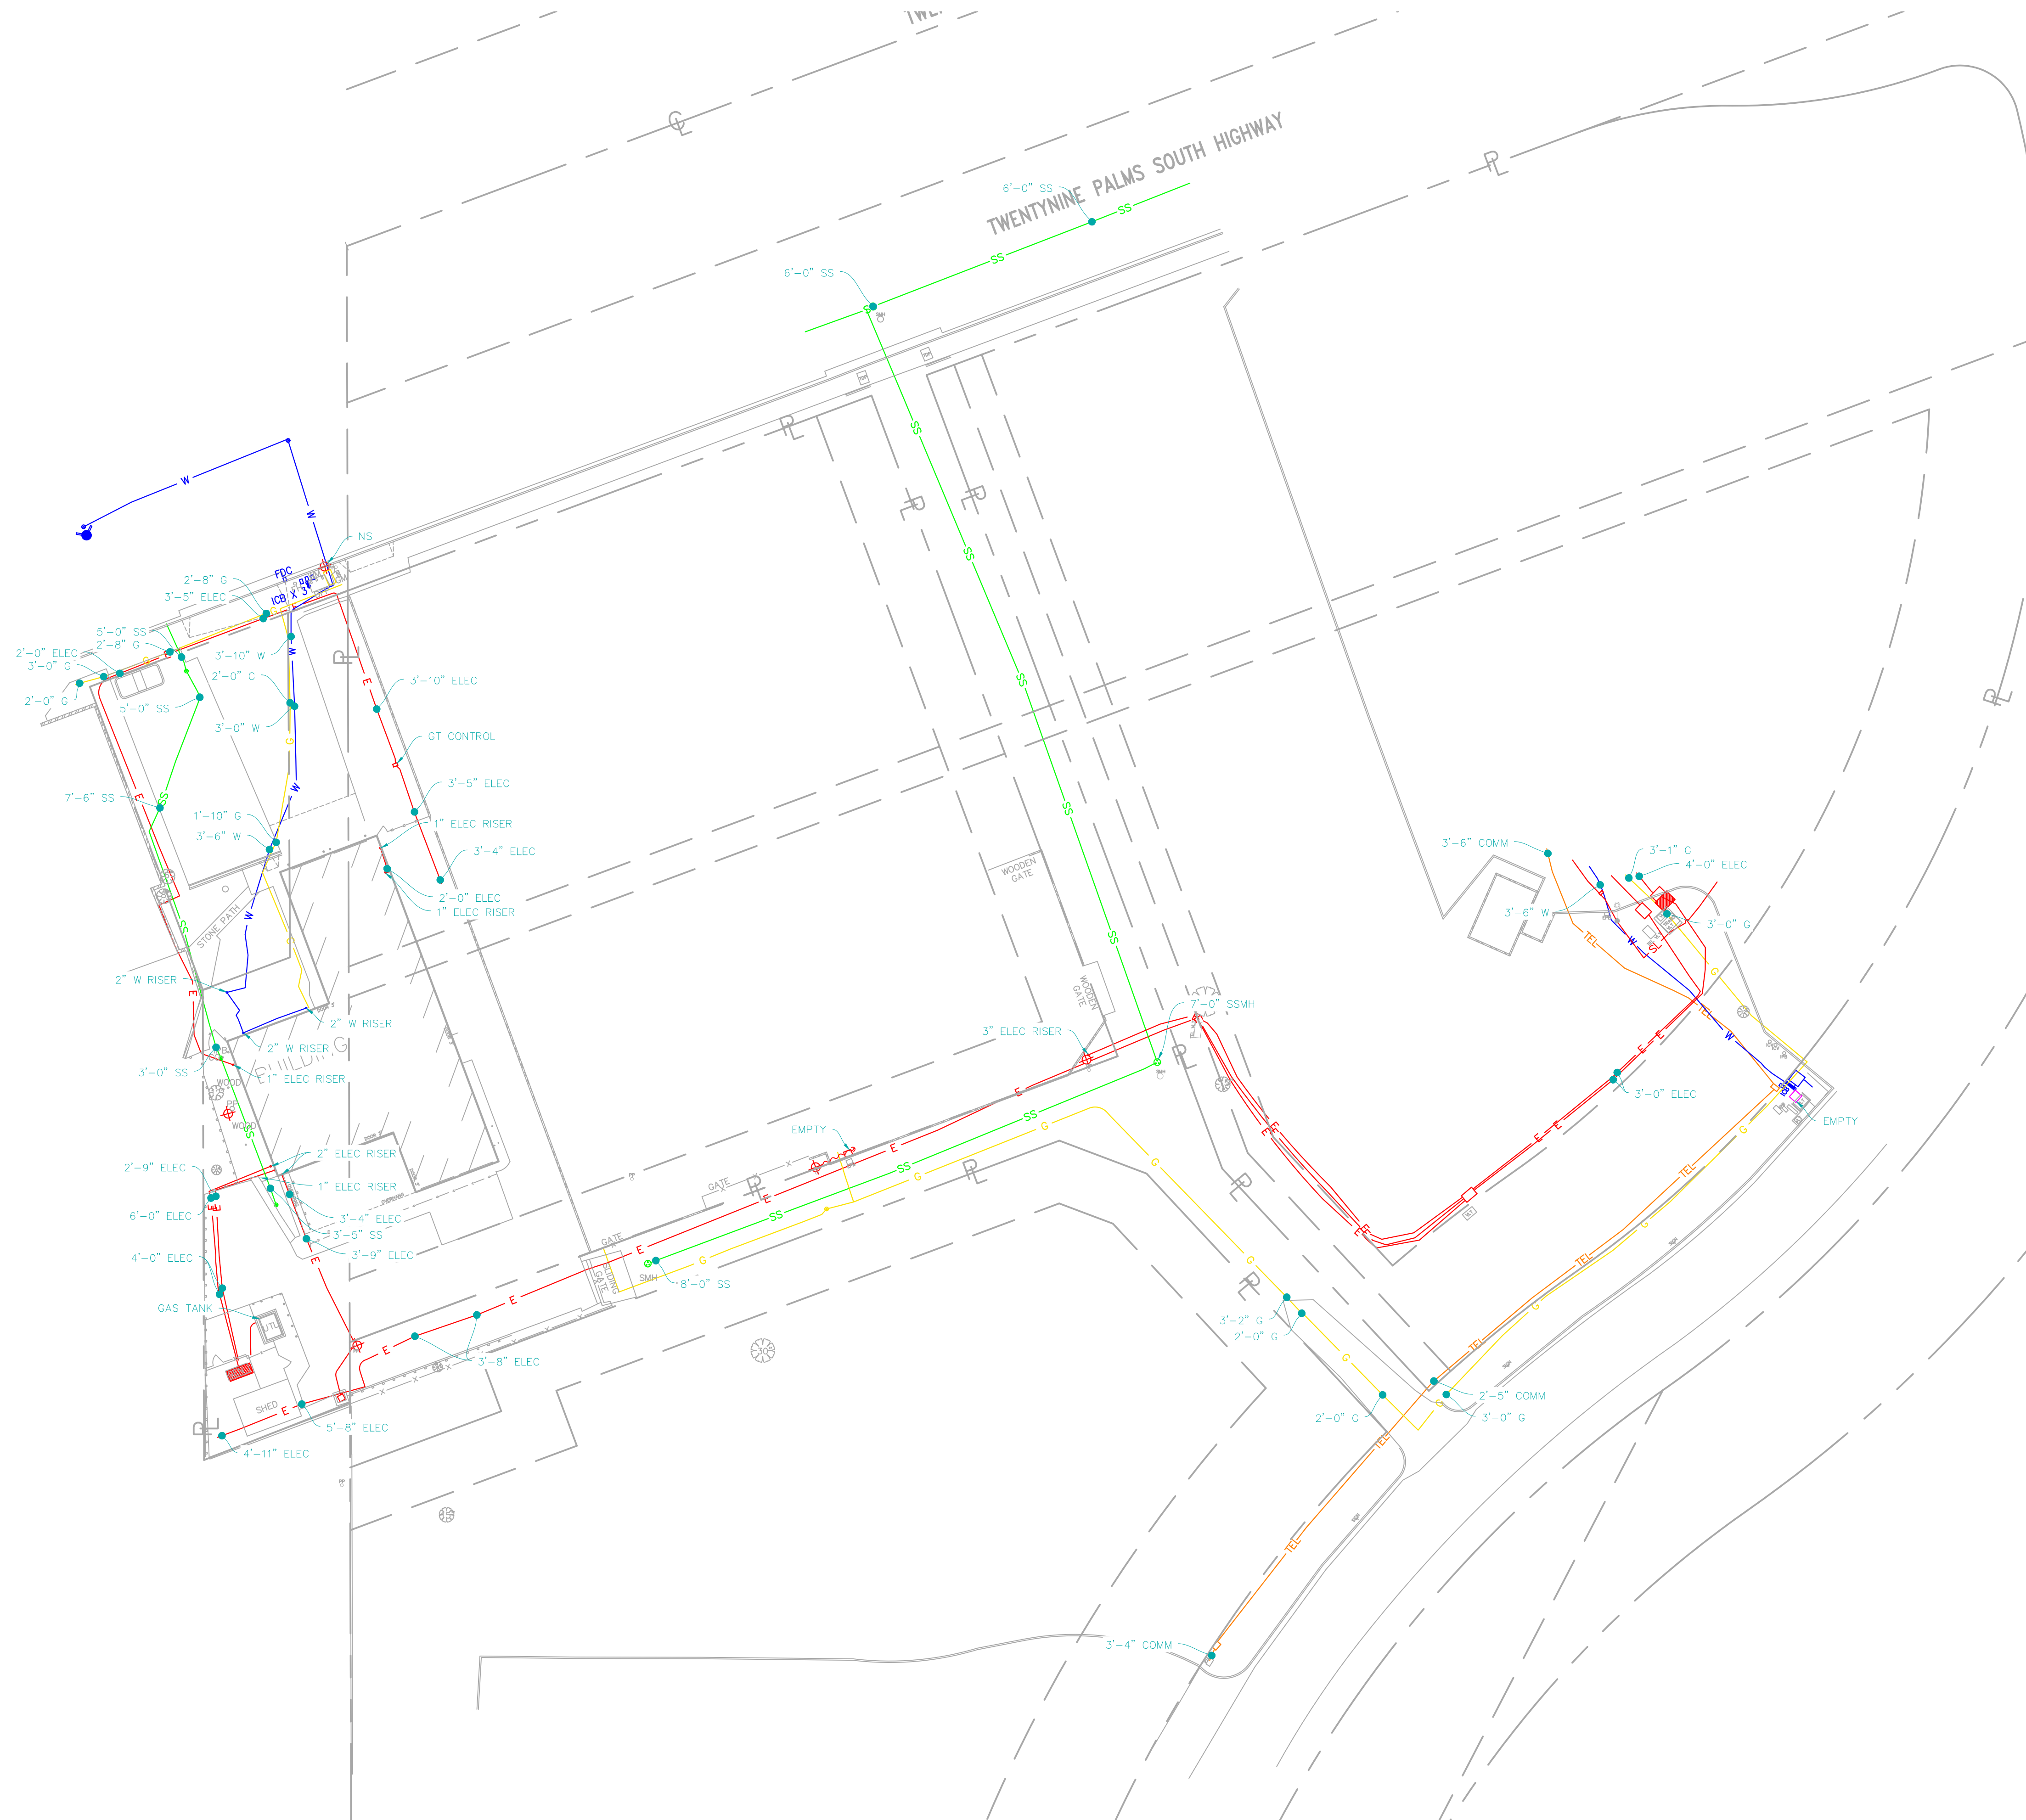

VICINITY MAP
N.T.S.

UTILITY NOTES

- FACILITIES (UTILITY LINES) SHALL BE LOCATED AND MARKED PRIOR TO EXCAVATION. CALL 811 FOR DIG ALERT.
- CONTRACTOR SHALL HAND-EXPOSE TO A POINT OF NO CONFLICT 24" ON EITHER SIDE OF THE UNDERGROUND FACILITY, REGARDLESS OF THE ESTIMATED DEPTH.
- DEPTHS SHOWN ARE APPROXIMATE, ESTIMATED DEPTHS ARE FROM THE GROUND SURFACE TO THE CENTER OF THE FACILITY. INVERT OF WASTE LINES, OR TO THE FACILITY TRACER WIRE. DEPTH ESTIMATES SHOULD BE USED WITH CAUTION AND MAY VARY ALONG THE LENGTH OF THE FACILITY.
- THE SCOPE OF THIS SURVEY DOES NOT INCLUDE FACILITY SIZE OR NUMBER OF CONDUIT IN MULTIPLE CONDUIT RUNS. IRRIGATION LINES ARE NOT INCLUDED IN THIS SURVEY.
- THE BACKGROUND SITE PLAN USED IN PREPARING THIS MAP WAS PREPARED BY OTHERS AND PROVIDED TO ULTRA ENGINEERING BY THE CLIENT. ULTRA ENGINEERING MAKES NO REPRESENTATION AS TO THE ACCURACY OF THE PLAN.
- IN THE EVENT THE INFORMATION SHOWN IN THIS PLAN VARIES FROM THE ACTUAL SITE CONDITIONS, ULTRA ENGINEERING SHALL BE NOTIFIED WITHIN 24 HOURS AFTER DISCOVERY OF THE CONFLICT.

LEGEND

- | | |
|------------------------------|-------|
| ELECTRICAL | —E— |
| TRAFFIC SIGNAL | —TS— |
| SITE LIGHT | —SL— |
| RAILROAD SIGNAL | —RR— |
| GAS | —G— |
| TEL/COMM | —TEL— |
| INTERCOM | —IC— |
| FIRE ALARM | —FA— |
| FIBER OPTIC | —FO— |
| TELEVISION | —TV— |
| WATER | —W— |
| SEWER | —SS— |
| STORM DRAIN | —SD— |
| POSSIBLE LINE LOCATION (UNK) | —U— |
-
- | | |
|------------------------|--|
| FIRE HYDRANT | |
| METER/PULL BOX | |
| VAULT | |
| VALVE | |
| STORM DRAIN INLET | |
| SITE LIGHT | |
| STREET LIGHT | |
| ELECTRICAL TRANSFORMER | |
| UNVERIFIED PATH | |
| GAS MANIFOLD | |
| WATER MAIN | |
| BACKFLOW | |
| OFFSET FROM REFERENCE | |
| DEPTH FROM SURFACE | |
| DIA. OF PIPE | |
- NLP = NO LONGER PUSH
NS = NO SIGNAL
EOS = END OF SIGNAL
NA = NO ACCESS
FDC = FIRE DEPARTMENT CONNECTION
GPR = GROUND PENETRATING RADAR LOCATED LINE


DATE LOCATED:	6/18/24
DRAWN BY/DATE:	7/18/24
TECHNICIAN:	AZ
CHECK BY/DATE:	HZ
QC CHECKED BY/DATE:	1 OF 2
SCALE:	1" = 30'
PROJECT NO.:	..

NO	DATE	BY	DESCRIPTION

PARTIAL UNDERGROUND UTILITY MAP FOR:
VCA ENGINEERING
1041 S GARFIELD AVE, SUITE 210, ALHAMBRA, CA 91801
YUCCA VALLEY FIRE
7238 JOSHUA LANE/
92284 TWENTYNINE PALMS OUTER HIGHWAY S,
YUCCA VALLEY, CA 92284

NOTES:
The services provided by Ultra Engineering are for the use of the Client and for property owner of the responsibility of having the Government Code §44216-4216.9. It is expressly understood by the Client and Ultra Engineering that the Engineering services are not a substitute for compliance with California Code §44216-4216.9.



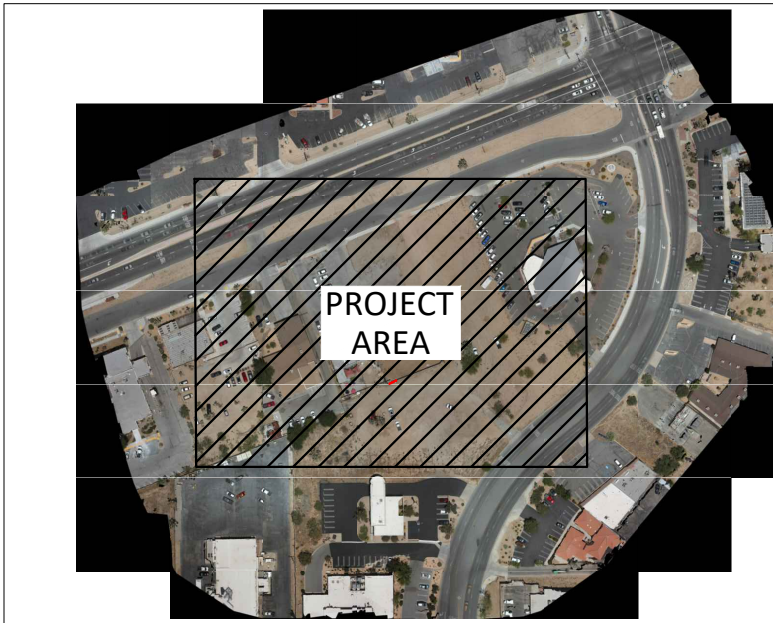


VICINITY MAP
N.T.S.

UTILITY NOTES

- FACILITIES (UTILITY LINES) SHALL BE LOCATED AND MARKED PRIOR TO EXCAVATION. CALL 811 FOR DIG ALERT.
- CONTRACTOR SHALL HAND-EXPOSE TO A POINT OF NO CONFLICT 24" ON EITHER SIDE OF THE UNDERGROUND FACILITY, REGARDLESS OF THE ESTIMATED DEPTH.
- DEPTHS SHOWN ARE APPROXIMATE, ESTIMATED DEPTHS ARE FROM THE GROUND SURFACE TO THE CENTER OF THE FACILITY. INVERT OF WASTE LINES, OR TO THE FACILITY TRACER WIRE, DEPTH ESTIMATES SHOULD BE USED WITH CAUTION AND MAY VARY ALONG THE LENGTH OF THE FACILITY.
- THE SCOPE OF THIS SURVEY DOES NOT INCLUDE FACILITY SIZE OR NUMBER OF CONDUIT IN MULTIPLE CONDUIT RUNS. IRRIGATION LINES ARE NOT INCLUDED IN THIS SURVEY.
- THE BACKGROUND SITE PLAN USED IN PREPARING THIS MAP WAS PREPARED BY OTHERS AND PROVIDED TO ULTRA ENGINEERING BY THE CLIENT. ULTRA ENGINEERING MAKES NO REPRESENTATION AS TO THE ACCURACY OF THE PLAN.
- IN THE EVENT THE INFORMATION SHOWN IN THIS PLAN VARIES FROM THE ACTUAL SITE CONDITIONS, ULTRA ENGINEERING SHALL BE NOTIFIED WITHIN 24 HOURS AFTER DISCOVERY OF THE CONFLICT.

LEGEND

- | | |
|------------------------------|-------|
| ELECTRICAL | —E— |
| TRAFFIC SIGNAL | —TS— |
| SITE LIGHT | —SL— |
| RAILROAD SIGNAL | —RR— |
| GAS | —G— |
| TEL/COMM | —TEL— |
| INTERCOM | —IC— |
| FIRE ALARM | —FA— |
| FIBER OPTIC | —FO— |
| TELEVISION | —TV— |
| WATER | —W— |
| SEWER | —SS— |
| STORM DRAIN | —SD— |
| POSSIBLE LINE LOCATION (UNK) | —U— |
-
- | | |
|------------------------|--------|
| FIRE HYDRANT | |
| METER/PULL BOX | |
| VAULT | |
| VALVE | |
| STORM DRAIN INLET | |
| SITE LIGHT | |
| STREET LIGHT | |
| ELECTRICAL TRANSFORMER | |
| UNVERIFIED PATH | --- |
| GAS MANIFOLD | |
| WATER MAIN | |
| BACKFLOW | |
| OFFSET FROM REFERENCE | 10'-8" |
| DEPTH FROM SURFACE | 1'-6" |
| DIA. OF PIPE | |
- NLP = NO LONGER PUSH
NS = NO SIGNAL
EOS = END OF SIGNAL
NA = NO ACCESS
FDC = FIRE DEPARTMENT CONNECTION
GPR = GROUND PENETRATING RADAR LOCATED LINE

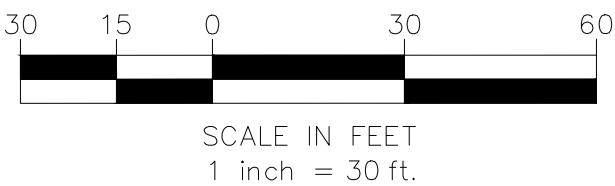

DATE LOCATED: 6/18/24
DRAWN BY/DATE: 7/18/24
TECHNICIAN: AZ
CHECK BY/DATE: HZ
QC CHECKED BY/DATE: 1 OF 2
SCALE: 1" = 30'
PROJECT NO: ..

REVISIONS

NO	DATE	BY	DESCRIPTION

PARTIAL UNDERGROUND UTILITY MAP FOR:
VCA ENGINEERING
1041 S GARFIELD AVE, SUITE 210, ALHAMBRA, CA 91801
YUCCA VALLEY FIRE
7238 JOSHUA LANE/
92284 TWENTYNINE PALMS OUTER HIGHWAY S,
YUCCA VALLEY, CA 92284

NOTES:
The services provided by Ultra Engineering are for the use of the Client and for property owner of the responsibility of having to comply with California Government Code §4216-4216.9. It is expressly understood by the Client that the services provided by Ultra Engineering are not a substitute for compliance with California Code §4216-4216.9.



38006 PEBLEY CT. WINCHESTER, CA 93296 | PHONE: 951-223-9552 | HTTP://WWW.ULTRAENGINEERING.COM